

**ADDENDUM NO. 4**

DATE: September 30, 2022

PROJECT: Benton Washington Regional Public Water Authority
Phase 1A – Water Treatment Plant Improvements – 4MG Elevated Storage Tank
Rogers, Arkansas

BID DATE: October 6, 2022, at 1:00PM

This Addendum forms a part of the Contract Documents and modifies the original documents provided to Bidders, as noted below. Acknowledge receipt of this Addendum in the space provided in the BID FORM. Failure to do so may subject the Bidder to disqualification.

Item No. 1. Modification to the Bid Form

1. Add the following sentence in Article 5: Basis of Bid
 - A. The Owner Shall award the Bid based on the lowest Base Bid, the lowest Base Bid minus Deductive Alternate 1 OR the lowest Base Bid minus Deductive Alternate 1 and 2, whichever option is in the best interest of the Owner.
2. Modify Article 6, 6.01 – Time of Completion as follows:
 - A. Bidder agrees that the Work will be substantially complete within ~~600~~ **700** calendar days after the date when the Contract Times commence to run as provided in Paragraph 4.01 of the General Conditions and will be completed and ready for final payment in accordance with Paragraph 15.06 of the General Conditions within ~~660~~ **750** calendar days after the date when the Contract Times commence to run.

Item No. 2. Division 00 Documents

1. Modify the Agreement, Article 4 – Contract Times as follows:
 - A. The Work will be substantially completed within ~~600~~ **700** calendar days after the date when the Contract Times commence to run as provided in Paragraph 4.01 of the General Conditions and completed and ready for final payment in accordance with Paragraph 15.06 of the General Conditions within ~~660~~ **750** calendar days after the date when the Contract Times commence to run.
2. Modify Notice to Proceed as follows:
 - A. On that date, Contractor shall start performing its obligations under the Contract Documents. No Work shall be done at the Site prior to such date. In accordance with the Agreement, the number of days to achieve Substantial Completion is ~~600~~ **700** consecutive calendar days, and the number of days to achieve readiness for final payment is ~~660~~ **750** consecutive calendar days.

Item No. 3. **Plans**

1. Remove sheet E1-Legends and Abbreviations and replace with sheet E1 – Legends and Abbreviations, Addendum No. 4.
2. Remove sheet E2-Electrical Site Plan and replace with sheet E2 – Electrical Site Plan, Addendum No. 4.
3. Remove sheet E3-Tank Section and replace with sheet E3-Tank Section, Addendum No. 4.
4. Remove sheet E4-Tank Plans and replace with sheet E4- Tank Plans, Addendum No. 4.
5. Add sheet 4A-Tank Plans, Addendum No. 4.
6. Remove sheet M1-Tank Plans-HVAC and replace with sheet M1-Tank Plans-HVAC, Addendum No. 4.

Item No. 4. **Modifications to Specification 221210**

1. Add Section 1.1.B:
 - B. All valve controllers shall be pre-programmed at the factory with control logic to ensure proper operation of the valve(s) before arriving to the jobsite.
2. Modify Section 2.2.D.21.a (accessories for inlet control valve):
 - A. **UP-22D Control Panel**, ~~VC-22D Valve Controller, EPC Power Converter~~, X141-PT Pressure Transmitters, X117D Valve Position Transmitter, Pilot System Ball Valves, SS Pressure Gauges, & Solenoid Manual Actuator.
3. Modify Section 2.3.D.16.a (accessories for outlet control valve):
 - A. UP-22D Universal Control Panel, X105LCW Limit Switch, **X117-D – Valve Position Transmitter**, and Check valve feature
4. Remove Section 2.8 in it's entirety
5. Modify Section 2.9 – ELECTRONIC VALVE CONTROL PANEL (~~OUTLET VALVE~~)
6. Modify Section 2.9.A.
 - A. Control Valve Manufacture shall provide control panel with **inlet and** outlet valve. Control panel shall be designed, manufactured, and tested by control valve manufacture. Electronic valve control panel shall be Cla-Val Model No. UP-22D.
7. Modify Section 2.10 – ELECTRONIC VALVE CONTROLLER (~~OUTLET VALVE~~)

END OF ITEMS

All other provisions of the Contract Documents remain unchanged. Acknowledge receipt of this addendum on the Bid Form. Bids must be received at Benton Washington Regional Public Water Authority office, 15531 Woods Lodge Road, Rogers, AR 72756 by 1:00 PM on October 6, 2022.

 
 
 




Matt Dunn, PE (Crist Engineers, Inc.)

09/30/2022

Date

POWER, LIGHTING & SYSTEM LEGEND

	CABINET LIGHT FIXTURE
	1x4 FLUORESCENT LIGHT
	2x4 FLUORESCENT LIGHT
	FLUORESCENT LIGHT WITH EMERGENCY LIGHT (EL) BATTERY 1400 LUMENS MINIMUM FOR 2 LAMPS
	2x2 FLUORESCENT LIGHT
	RECESSED LIGHT, UNLESS OTHERWISE SHOWN
	WALL MOUNTED LIGHT—MOUNTING HEIGHT AS INDICATED
	LED EXIT LIGHT, CEILING MOUNTED OR AS INDICATED, DARKENED AREA INDICATES FACE, ARROWS INDICATE DIRECTION OF EGRESS
	EMERGENCY EXIT LIGHT, WALL MOUNT 7'-6" A.F.F. OR AS NOTED
	4 FT. STRIP FLUORESCENT LIGHT
	LIGHT SWITCH, MTD. 4'-0" A.F.F.
	LIGHT SWITCH, 2 POLE, MTD 4'-0" A.F.F.
	LIGHT SWITCH, 3-WAY, MTD. 4'-0" A.F.F.
	LIGHT SWITCH, 4-WAY, MTD. 4'-0" A.F.F.
	LIGHT SWITCH WITH PILOT LIGHT, MTD. 4'-0" A.F.F.
	20 AMP DUPLEX RECEPTACLE MTD. HORIZ. 6" ABOVE COUNTER TOP UNLESS OTHERWISE SHOWN
	20 AMP DUPLEX RECEPTACLE MTD. 18" A.F.F., WITH #12 GROUND WIRE, GFCI INDICATES GROUND FAULT CIRCUIT INTERRUPTER, WP INDICATES WEATHERPROOF WHILE IN USE ENCLOSURE AND COVER
	SINGLE RECEPTACLE, RATINGS AS NOTED
	HP RATED TOGGLE SWITCH, 1 OR 2 POLES AS REQUIRED W/OVERLOADS
	NON-FUSED DISCONNECT SWITCH, SIZE AS NOTED
	COMBINATION DISCONNECT AND MOTOR STARTER, SIZE AS NOTED. FUSED TYPE SHOWN.
	FUSED DISCONNECT SWITCH, SIZE AS NOTED
	PUSHBUTTON STATION, NEMA 4X
	ELECTRICAL PANEL, SURFACE MOUNTED, 5'-6" TO TOP OF ENCLOSURE
	ELECTRICAL PANEL, RECESSED MOUNTED, 5'-6" TO TOP OF ENCLOSURE
	EQUIPMENT CABINET SIZE AS NOTED, RECESSED MOUNTED, 5'-6" TO TOP OF ENCLOSURE
	EQUIPMENT CABINET SIZE AS NOTED, SURFACE MOUNTED, 5'-6" TO TOP OF ENCLOSURE
	HOME RUN TO PANEL, RECEPTACLES AND EQUIPMENT SHALL HAVE GREEN GROUND WIRE. NUMBER OF ARROWS INDICATES NUMBER OF PHASE CONDUCTORS, LETTER(S) INDICATE NAME OF PANEL, NUMBER(S) INDICATE CIRCUIT NUMBERS
	BRANCH CIRCUIT WITH PHASE, NEUTRAL, SWITCHED PHASE AND EQUIPMENT GROUNDING CONDUCTORS
	TELEPHONE OR DATA OUTLET, SINGLE GANG BOX MTD. 18" A.F.F. WITH 3/4" C STUB TO ABOVE LAY-IN CEILING. "W" INDICATES 4'-6" MTD. HEIGHT FOR WALL PHONE.

  	3/4" PLYWOOD TELEPHONE BACKBOARD, SIZE AS NOTED, MTD. 5'-6" TO TOP
	JUNCTION BOX 42 CUBIC INCH MINIMUM CAPACITY
	SMOKE DETECTOR, WALL MTD.
	SMOKE DETECTOR, CEILING MTD.
	FIRE ALARM PULL STATION MTD. 4'-0" A.F.F.
	FIRE ALARM PULL STATION MTD. 4'-0" A.F.F. AND HORN MTD. 7'-0" A.F.F.
	SMOKE DETECTOR, HVAC DUCT MTD.
	FIRE ALARM CHIME 7'-0" A.F.F.
	SPRINKLER FLOW SWITCH
	FLOOR TELEPHONE OUTLET, CAST JUNCTION-BOX
	WALL TELEPHONE/DATA OUTLET
	DOOR SWITCH MOUNTED IN DOOR JAMB
	DOOR BUTTON WEATHER PROOF, 50" A.F.F.
	DOOR BUZZER MTD 7'-0" A.F.F.
	HANDHOLE OR MANHOLE, IDENTIFIER SHOWN, REFER TO HANDHOLE OR MANHOLE SCHEDULE FOR SIZE
	
	CIRCUIT BREAKER, TRIP RATING SHOWN, 3-POLE UNLESS NOTED
	FUSE, CURRENT LIMITING, RATING AS SHOWN
	TRANSFORMER, RATINGS AS SHOWN
	ELECTRIC MOTOR, HORSEPOWER SHOWN
	MOTOR STARTER, SIZE AS SHOWN OR REQUIRED. FVNR UNLESS NOTED
	VARIABLE FREQUENCY DRIVE
	DUCT BANK, IDENTIFIER SHOWN. REFER TO DUCT BANK SCHEDULE FOR SIZE AND CONFIGURATION.
	3/4" x 10' COPPER CLAD GROUND ROD
	SURGE ARRESTOR
	GENERATOR
	ATS
	WEATHERHEAD
	CABLE CONNECTION

<u>2(3#8 + 1#8 + 1#10EG)</u>	<u>3/4" GRS</u>	
		CONDUIT TYPE (SEE ABBREVIATIONS) REFER TO SPECIFICATIONS IF NOT SHOWN
		CONDUIT SIZE
		GROUNDING (GROUND) CONDUCTOR, NUMBER AND SIZE
		GROUND (NEUTRAL) CONDUCTOR, NUMBER AND SIZE
		PHASE (HOT) CONDUCTOR, NUMBER AND SIZE
		NUMBER OF SETS

ABBREVIATIONS

A	AMP	TC	TIME CLOCK
ACU	AIR CONDITIONING UNIT	TEL	TELEPHONE
AFF	ABOVE FINISHED FLOOR	TD	TIME DELAY
AIC	AMPS INTERRUPTING CAPACITY	TDD	TIME DELAY ON DE-ENERGIZATION
AM	AMP-METER	TDE	TIME DELAY ON ENERGIZATION
ANN	ANNUNCIATOR	TYP	TYPICAL
AP	AERIAL PRIMARY	TVSS	TRANSIENT VOLTAGE SURGE SUPPRESSOR
AS	AERIAL SECONDARY	UG	UNDER GROUND
AUX	AUXILIARY	UH	UNIT HEATER
BFI	BLOWN FUSE INDICATOR	UP	UNDERGROUND PRIMARY
BKR	BREAKER	US	UNDERGROUND SECONDARY
C	CONDUIT	VA	VOLT-AMP
CGRS	PVC COATED GALVANIZED RIGID STEEL	VFD	VARIABLE FREQUENCY DRIVE
CKT	CIRCUIT	VM	VOLT-METER
COM	COMMON	W	WATT OR WIRE
CONT	CONTINUOUS	WH	WEATHER HEAD
CP	CONTROL PANEL	WM	WATT METER
CPT	CONTROL POWER TRANSFORMER	WP	WEATHERPROOF
CR	CONTROL RELAY	W/	WITH
CS	CORD SET	XMFR	TRANSFORMER

CONTROL SCHEMATIC LEGEND


-----		WIRING TO FIELD DEVICE
	PUSHBUTTON SWITCH, NORMALLY OPEN	
	PUSHBUTTON SWITCH, NORMALLY CLOSED	
	SELECTOR SWITCH, NUMBER OF POSITIONS AND CONTACTS AS SHOWN	
	RELAY CONTACT, NORMALLY OPEN	
	RELAY CONTACT, NORMALLY CLOSED	
	TIME DELAY CONTACT, CLOSE ON ENERGIZATION	
	TIME DELAY CONTACT, OPEN ON ENERGIZATION	
	TIME DELAY CONTACT, OPEN ON DE-ENERGIZATION	
	TIME DELAY CONTACT, CLOSE ON DE-ENERGIZATION	
	LEVEL SWITCH	
	PRESSURE SWITCH	
	LIMIT SWITCH CONTACT, NORMALLY OPEN	
	LIMIT SWITCH CONTACT, NORMALLY CLOSED	
	LIMIT SWITCH CONTACT, HELD OPEN	
	LIMIT SWITCH CONTACT, HELD CLOSED	
	RELAY COIL, "TR" INDICATES "TIMING RELAY"	
	PILOT LIGHT; "A" INDICATES "AMBER LENS" "G" INDICATES "GREEN LENS" "R" INDICATES "RED LENS"	
	SOLENOID	
	ELAPSED TIME METER	
	TERMINAL BLOCK	
	ELECTRICAL CONNECTION	
	FUSE, AMPERE RATING AS SHOWN OR REQUIRED "BF" INDICATES "BLOWN FUSE INDICATOR" TYPE	
	GROUND CONNECTION TO ENCLOSURE GROUND BAR	

GENERAL NOTE:

1. SOME SYMBOLS OR ABBREVIATIONS MAY APPEAR ON THIS SHEET AND NOT BE UTILIZED ON THE PROJECT.

[illegible]

P:\PRODUCTION\PROJECTS\CRIST ENGINEERS (CRI)\024 BWPWA ELEVATED TANK\DWG\E02_SITE PLAN.DWG
9/23/2022 12:01 PM
CRIST ENGINEERS, INC.
COPYRIGHT ©

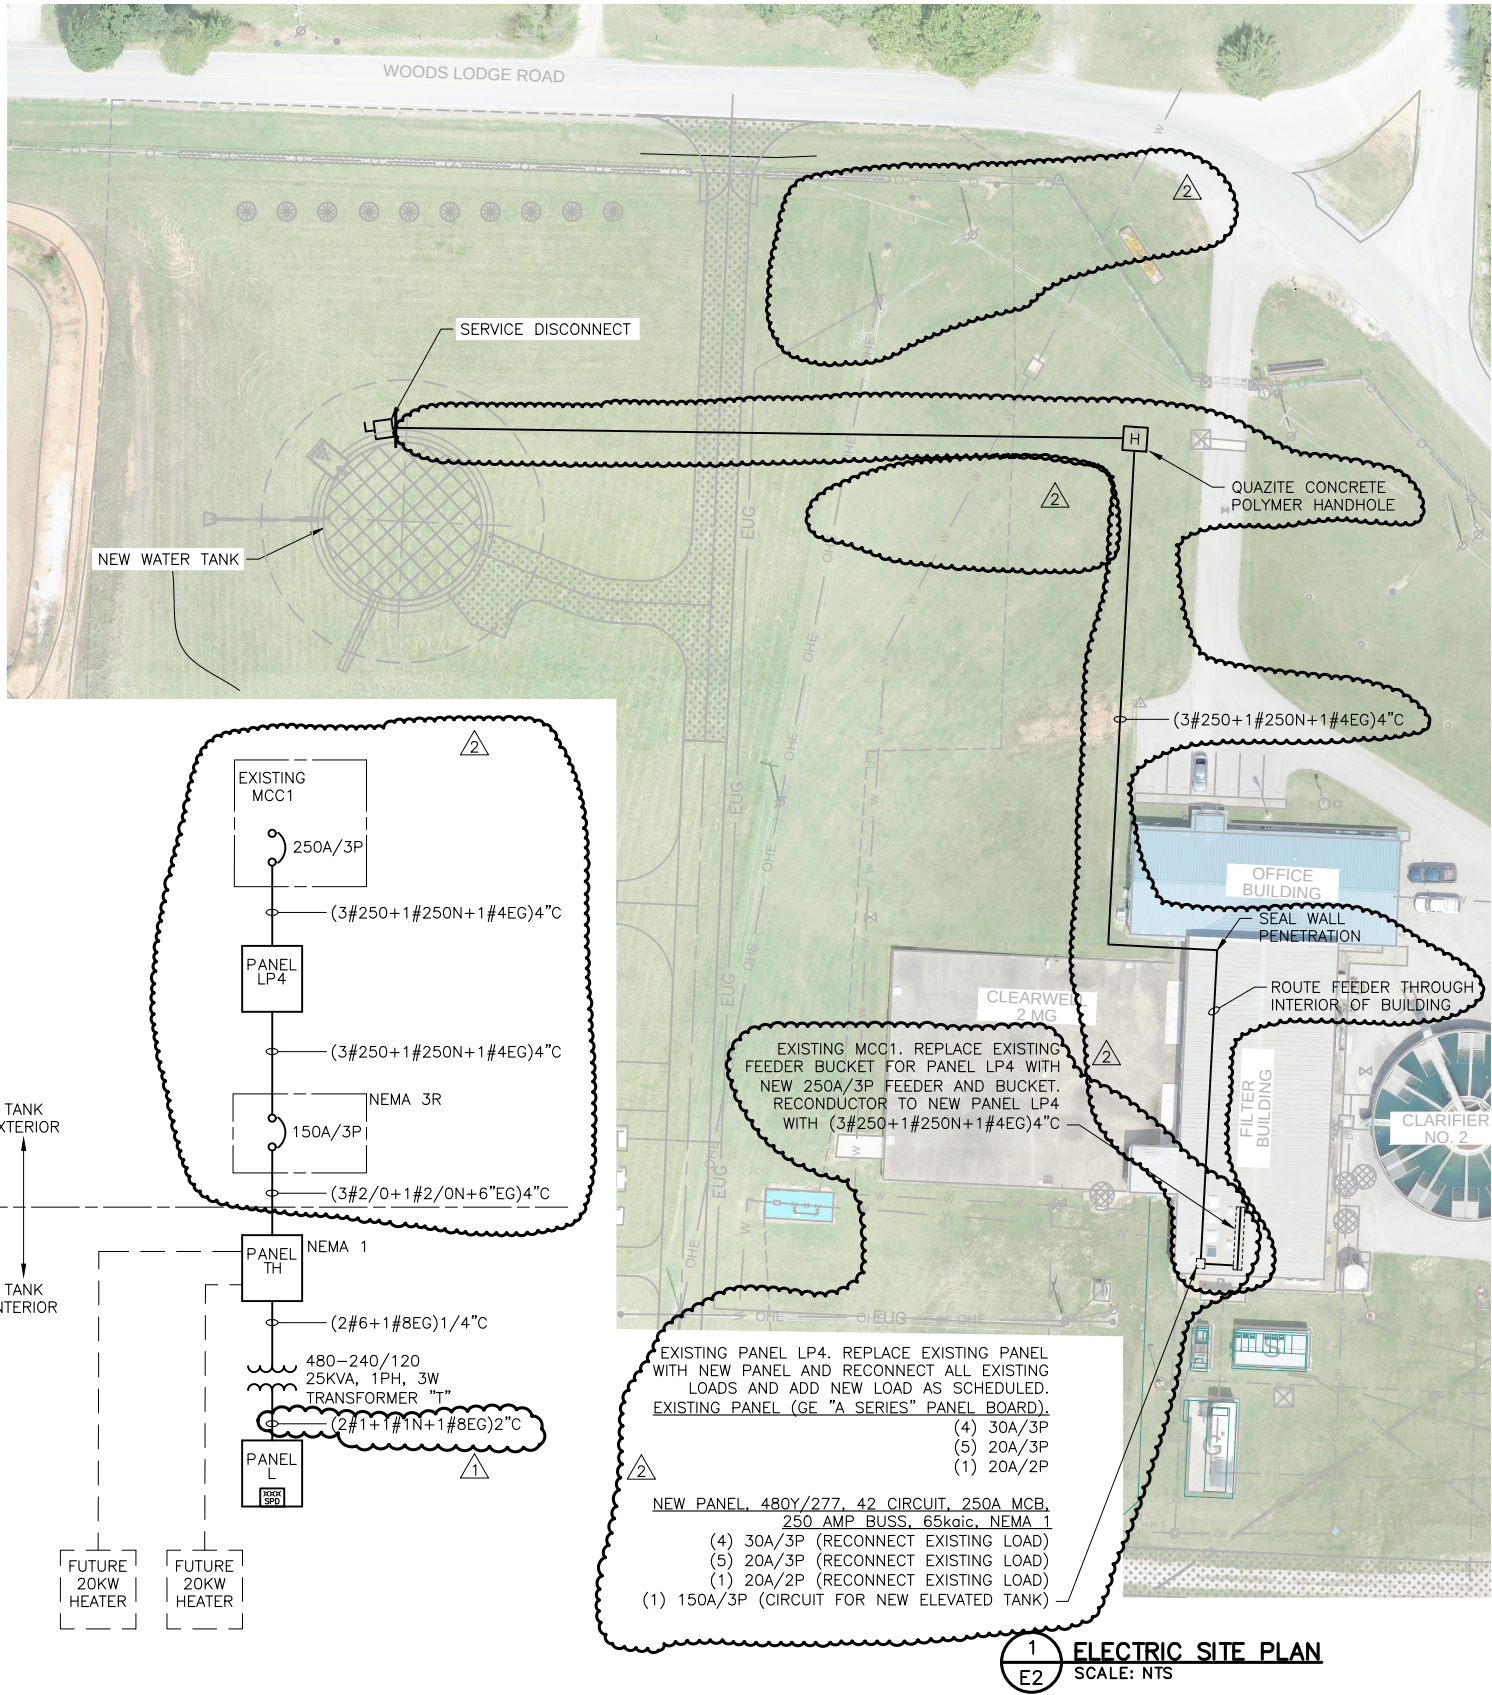

PANELBOARD SCHEDULE										
PANEL: "L"			VOLTS: 240/120 1PH, 3W		MAIN: 125A MCB			35,000 AIC		
DESCRIPTION	BKR	NO.	A	B	A	B	NO.	BKR	DESCRIPTION	
RECEPTACLE GROUND FLOOR	20A/1P	1	0.900		0.000		2	60A/2P	SURGE PROTECTIVE DEVICE	
SPARE	20A/1P	3		0.000		0.000	4	—	SURGE PROTECTIVE DEVICE	
MEZZ RECEPTACLE	20A/1P	5	0.900		1.800		6	30A/1P	JIB CRANE	
TOWER RECEPTACLE	20A/1P	7		0.360		1.800	8	—	JIB CRANE	
SPARE	20A/1P	9	0.000		0.936		10	20A/1P	GROUND FLOOR LIGHTING	
EMERGENCY LIGHTS	20A/1P	11		0.018		1.078	12	20A/1P	MEZZ. LIGHTS	
SPARE	20A/1P	13	0.000		0.140		14	20A/1P	TOWER LIGHTING	
LIGHTS OUTDOOR	20A/1P	15		0.003		0.029	16	20A/1P	EXTERIOR LIGHTING	
HIGH BAY FIXTURE	20A/1P	17	0.655		0.200		18	20A/1P	OBSTRUCTION LIGHT	
HEAT TRACE	20A/2P	19		1.000		1.000	20	20A/2P	HEAT TRACE	
HEAT TRACE	—	21	1.000		1.000		22	—	HEAT TRACE	
HEAT TRACE	20A/2P	23		1.000		1.000	24	20A/2P	HEAT TRACE	
HEAT TRACE	—	25	1.000		1.000		26	—	HEAT TRACE	
SPARE	20A/1P	27		0.000		0.000	28	20A/2P	SPARE	
SPARE	20A/1P	29	0.000		0.000		30	—	—	
SPARE	20A/1P	31		0.000		0.000	32	20A/2P	SPARE	
SPARE	20A/1P	33	0.000		0.000		34	—	—	
SPARE	20A/1P	35		0.000		1.000	36	20A/1P	UCP—1	
SPARE	20A/1P	37	0.000		1.000		38	20A/1P	UCP—2	
		39		0.000		0.000	40			
		41	0.000		0.000		42			
			4.455	2.381	6.076	5.907				
			10.531	8.288	TOTAL CONNECTED KVA					
			18.819							
			29.405		DESIGN KVA					
			123		DESIGN AMPS					

PANELBOARD SCHEDULE											
PANEL	"TH"	VOLTS	480Y/277, 3PH, 4W	MAIN	150A MCB 	INTERRUPT RATING			65,000		
DESCRIPTION	BKR	NO.	A	B	C	A	B	C	NO.	BKR	DESCRIPTION
EUH-1	30A/3P	1	6.667			0.000			2	60A/3P	SURGE PROTECTIVE DEVICE
EUH-1	-	3		6.667			0.000		4	-	
EUH-1	-	5			6.667			0.000	6	-	
EUH-2	30A/3P	7	6.667			0.000			8		
EUH-2	-	9		6.667			0.000		10		
EUH-2	-	11			6.667			0.000	12		
PANEL L	70A/2P	13	12.500			0.000			14		
	-	15		12.500			0.000		16		
	-	17			0.000			0.000	18		
SPARE	40A/3P	19	0.000			0.000			20		
	-	21		0.000			0.000		22		
	-	23			0.000			0.000	24		
SPARE	40A/3P	25	0.000			0.000			26		
	-	27		0.000			0.000		28		
	-	29			0.000			0.000	30		
		31	0.000			0.000			32		
		33		0.000			0.000		34		
		35			0.000			0.000	36		
		37	0.000			0.000			38		
		39		0.000			0.000		40		
		41			0.000			0.000	42		
			25.8340	25.8340	13.3340	0.0000	0.0000	0.0000			
			25.8340	25.8340	13.3340	TOTAL CONNECTED KVA					
			65.0020			DESIGN KVA					
			101.5656								
			122.168044			DESIGN AMPS	Ⓢ	480			

REV. NO.	DATE	DRWN	CHKD	REMARKS
2	9-21-22	CD	BB	ADDENDUM 3
1	8-31-22	CD	BB	ADDENDUM 1



THIS LINE MEASURES 1" WHEN PLOTTED FULL SIZE

DESIGNED:	BB
DRAFTED:	CD
CHECKED:	BB
DATE:	AUGUST 2022




CRIST ENGINEERS, INC.
CONSULTING ENGINEERS
205 EXECUTIVE COURT
LITTLE ROCK, ARKANSAS 72205
TELEPHONE: (501) 664-1552
FAX: (501) 664-8579
WWW.CRISTENGINEERS.COM


ROGERS, ARKANSAS
CAPITAL IMPROVEMENTS PLAN PHASE 1A
WATER TREATMENT PLANT IMPROVEMENTS
ELECTRICAL
SITE PLAN

BE BROWN
ENGINEERS
501-448-0100
JOB NO.
CRI-024
SHEET NO.
E2


P:\PRODUCTION\PROJECTS\CRIST ENGINEERS (CRI)\024 BWPWA ELEVATED TANK\DWG\E03_ TANK ELEVATION.DWG
9/23/2022 12:18 PM
CRIST ENGINEERS, INC.

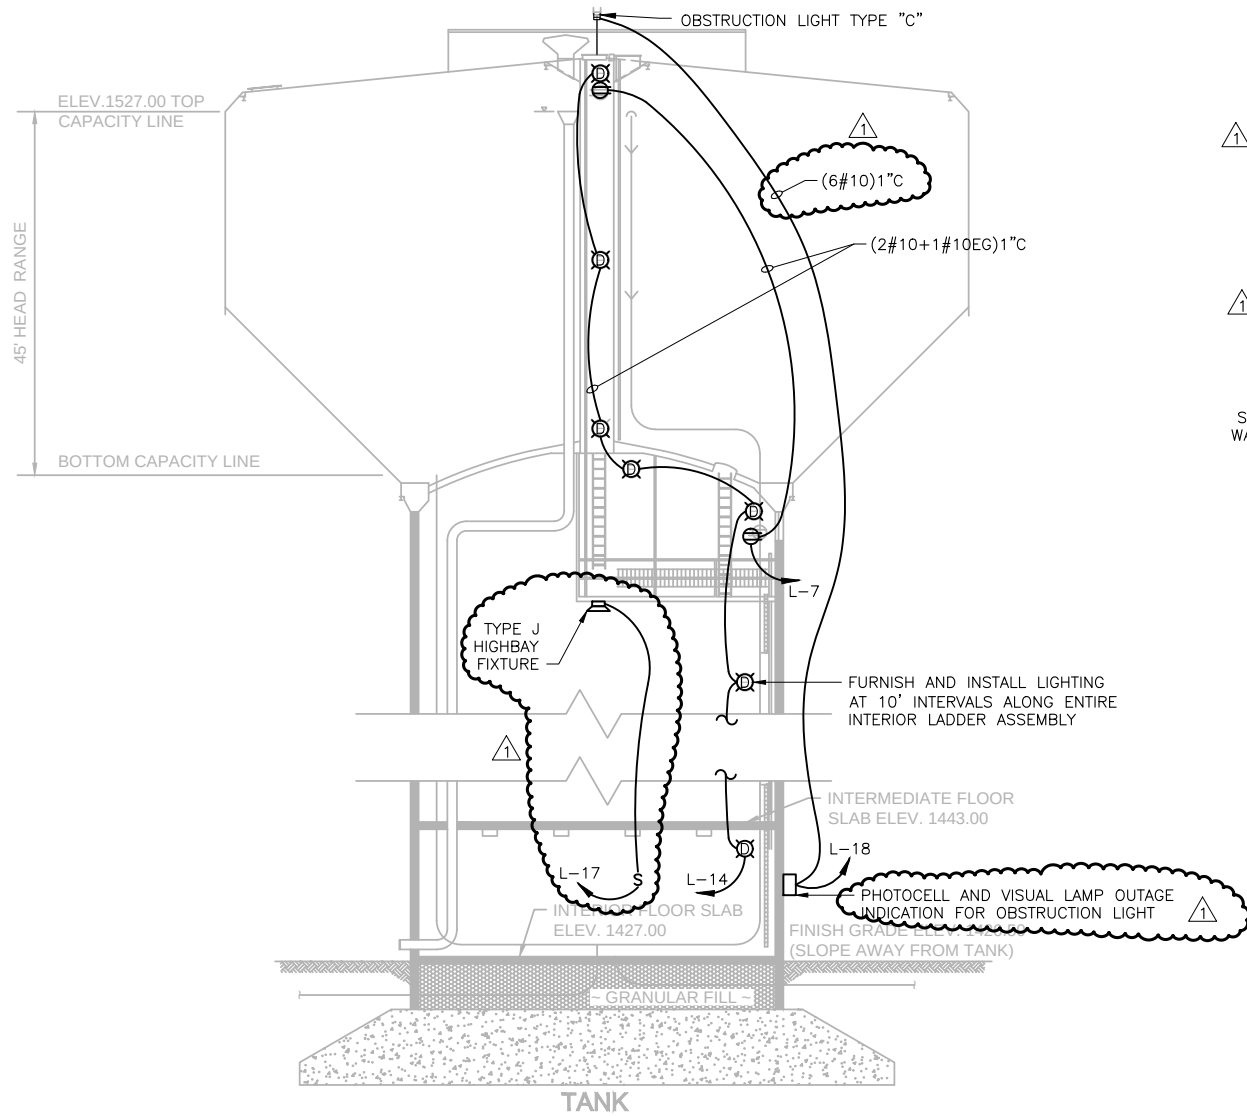

1 TANK SECTION
E3 SCALE: NONE

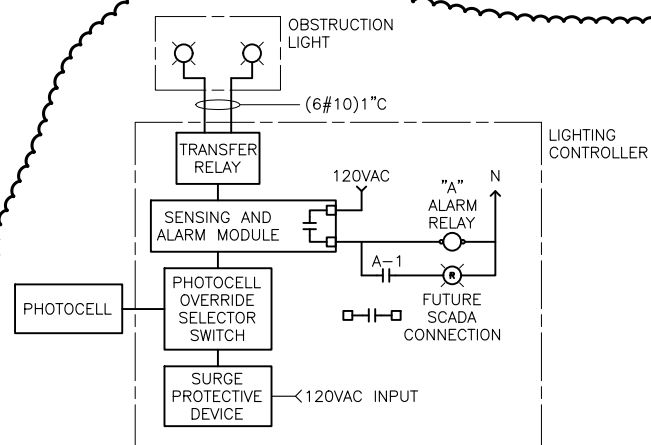


5 OBSTRUCTION LIGHTING WIRING DIAGRAM
E3 SCALE: NONE

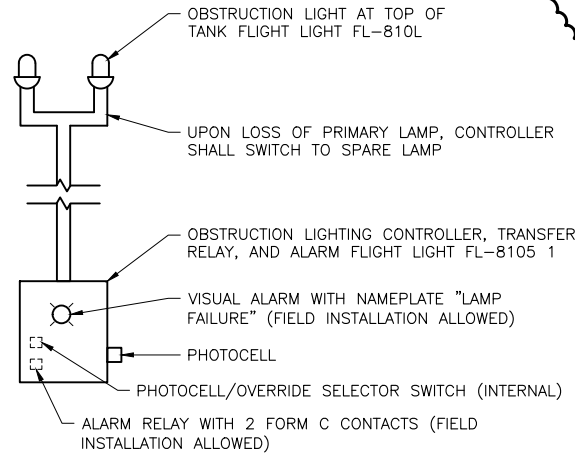


6 OBSTRUCTION LIGHTING RISER DIAGRAM
E3 SCALE: NONE


MARK	MANUFACTURER	CATALOG NUMBER	DESCRIPTION	LAMPS	VOLTAGE	MOUNTING	REMARKS/ACCEPTABLE MANUFACTURER
A	RIGALITE	ML09LC4U RIG	LED STRIP	72W LED	120V		
B	RIGALITE	ML11LC4U MR	WALL MOUNT LED	72W LED	120V	WALL MOUNT	
C	FLIGHT LIGHT	FL-810L-R-AC-D-X-X	L-810 (L) DOUBLE OBSTRUCTION LIGHT	(2) LED	120V		WITH FLIGHT LIGHT OBSTRUCTION LIGHTING CONTROLLER, TRANSFER RELAY, AND AND (OR EQUAL) FL-81051
D	HUBBELL	VL15G-X	WALL MOUNT LED	20W LED	120V	WALL MOUNT	
E	DUAL LITE	PGX	LED EMERGENCY LIGHT	3W	120V	WALL MOUNT	
F	DUAL LITE	SEWL SRBE	LED EXIT SIGN	3W	120V	WALL MOUNT	
G	DUAL LITE	DYN1206L	LED EMERGENCY LIGHT	(2)6W LED	120V	WALL MOUNT	
H	HUBBELL	LNC2-12L-4K-070-3U-PBT-PCU	SMALL LED LITEPAK	29W LED	120V	WALL MOUNT	
J	AZZ	HLB-7-U-40	HIGHBAY	513W LED	120V		MOUNT BELOW CATWALK

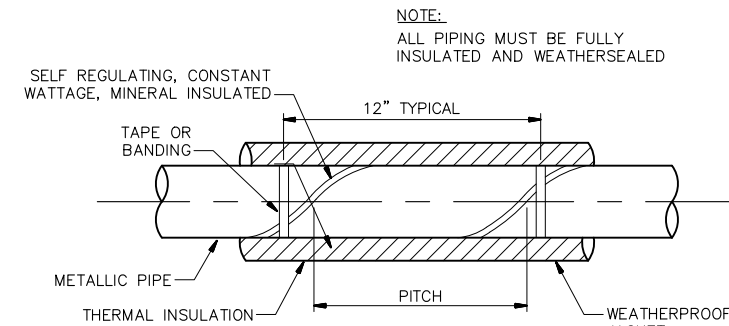

2 HEAT TRACE DETAIL II
E3 SCALE: NONE

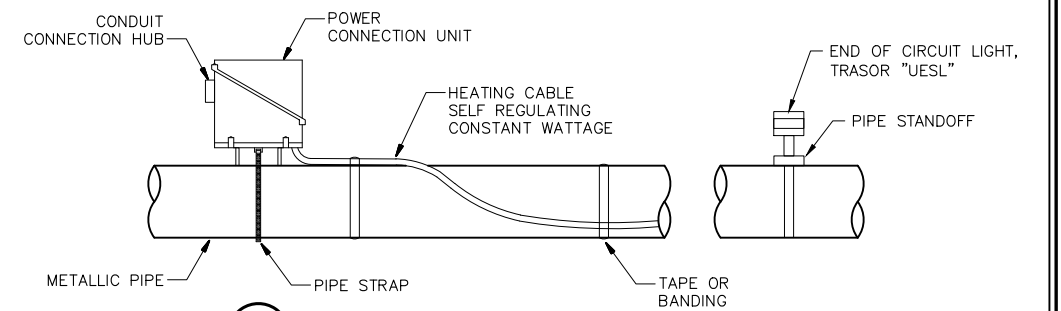

3 HEAT TRACE DETAIL I
E3 SCALE: NONE

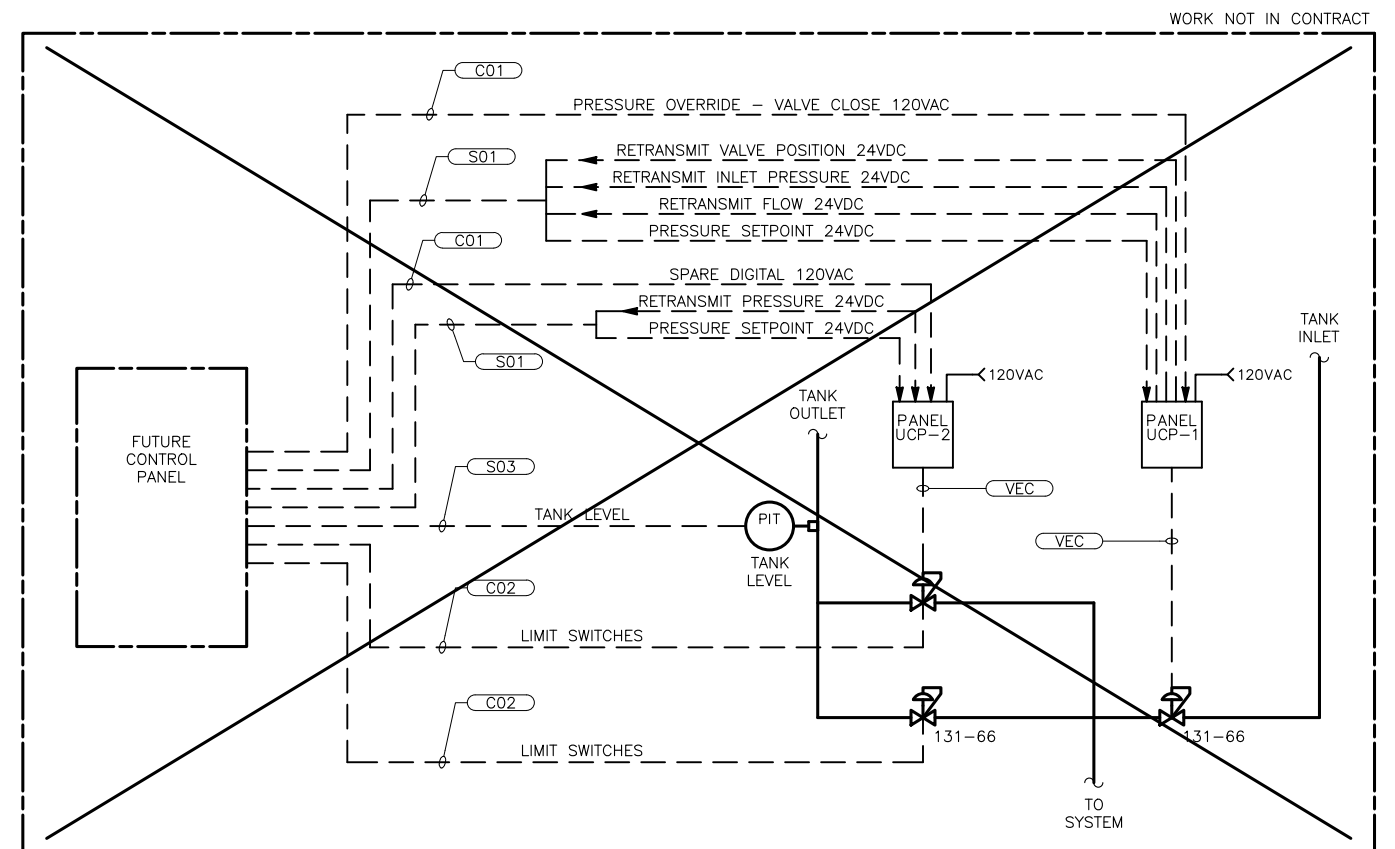

4 FUTURE TANK VALVE CONTROLS
E3 SCALE: NONE

REV. NO.	DATE	DRWN	CHKD	REMARKS
1	9-21-22	CD	BB	ADDENDUM 3



0 1" = 1"
THIS LINE MEASURES 1" WHEN PLOTTED FULL SIZE

DESIGNED:	BB
DRAFTED:	CD
CHECKED:	BB
DATE:	AUGUST 2022




CRIST ENGINEERS, INC.
CONSULTING ENGINEERS
205 EXECUTIVE COURT
LITTLE ROCK, ARKANSAS 72205
TELEPHONE: (501) 664-1552
FAX: (501) 664-8579
WWW.CRISTENGINEERS.COM

ROGERS, ARKANSAS
CAPITAL IMPROVEMENTS PLAN PHASE 1A
WATER TREATMENT PLANT IMPROVEMENTS

ELECTRICAL
TANK SECTION



JOB NO.
CRI-024
SHEET NO.
E3

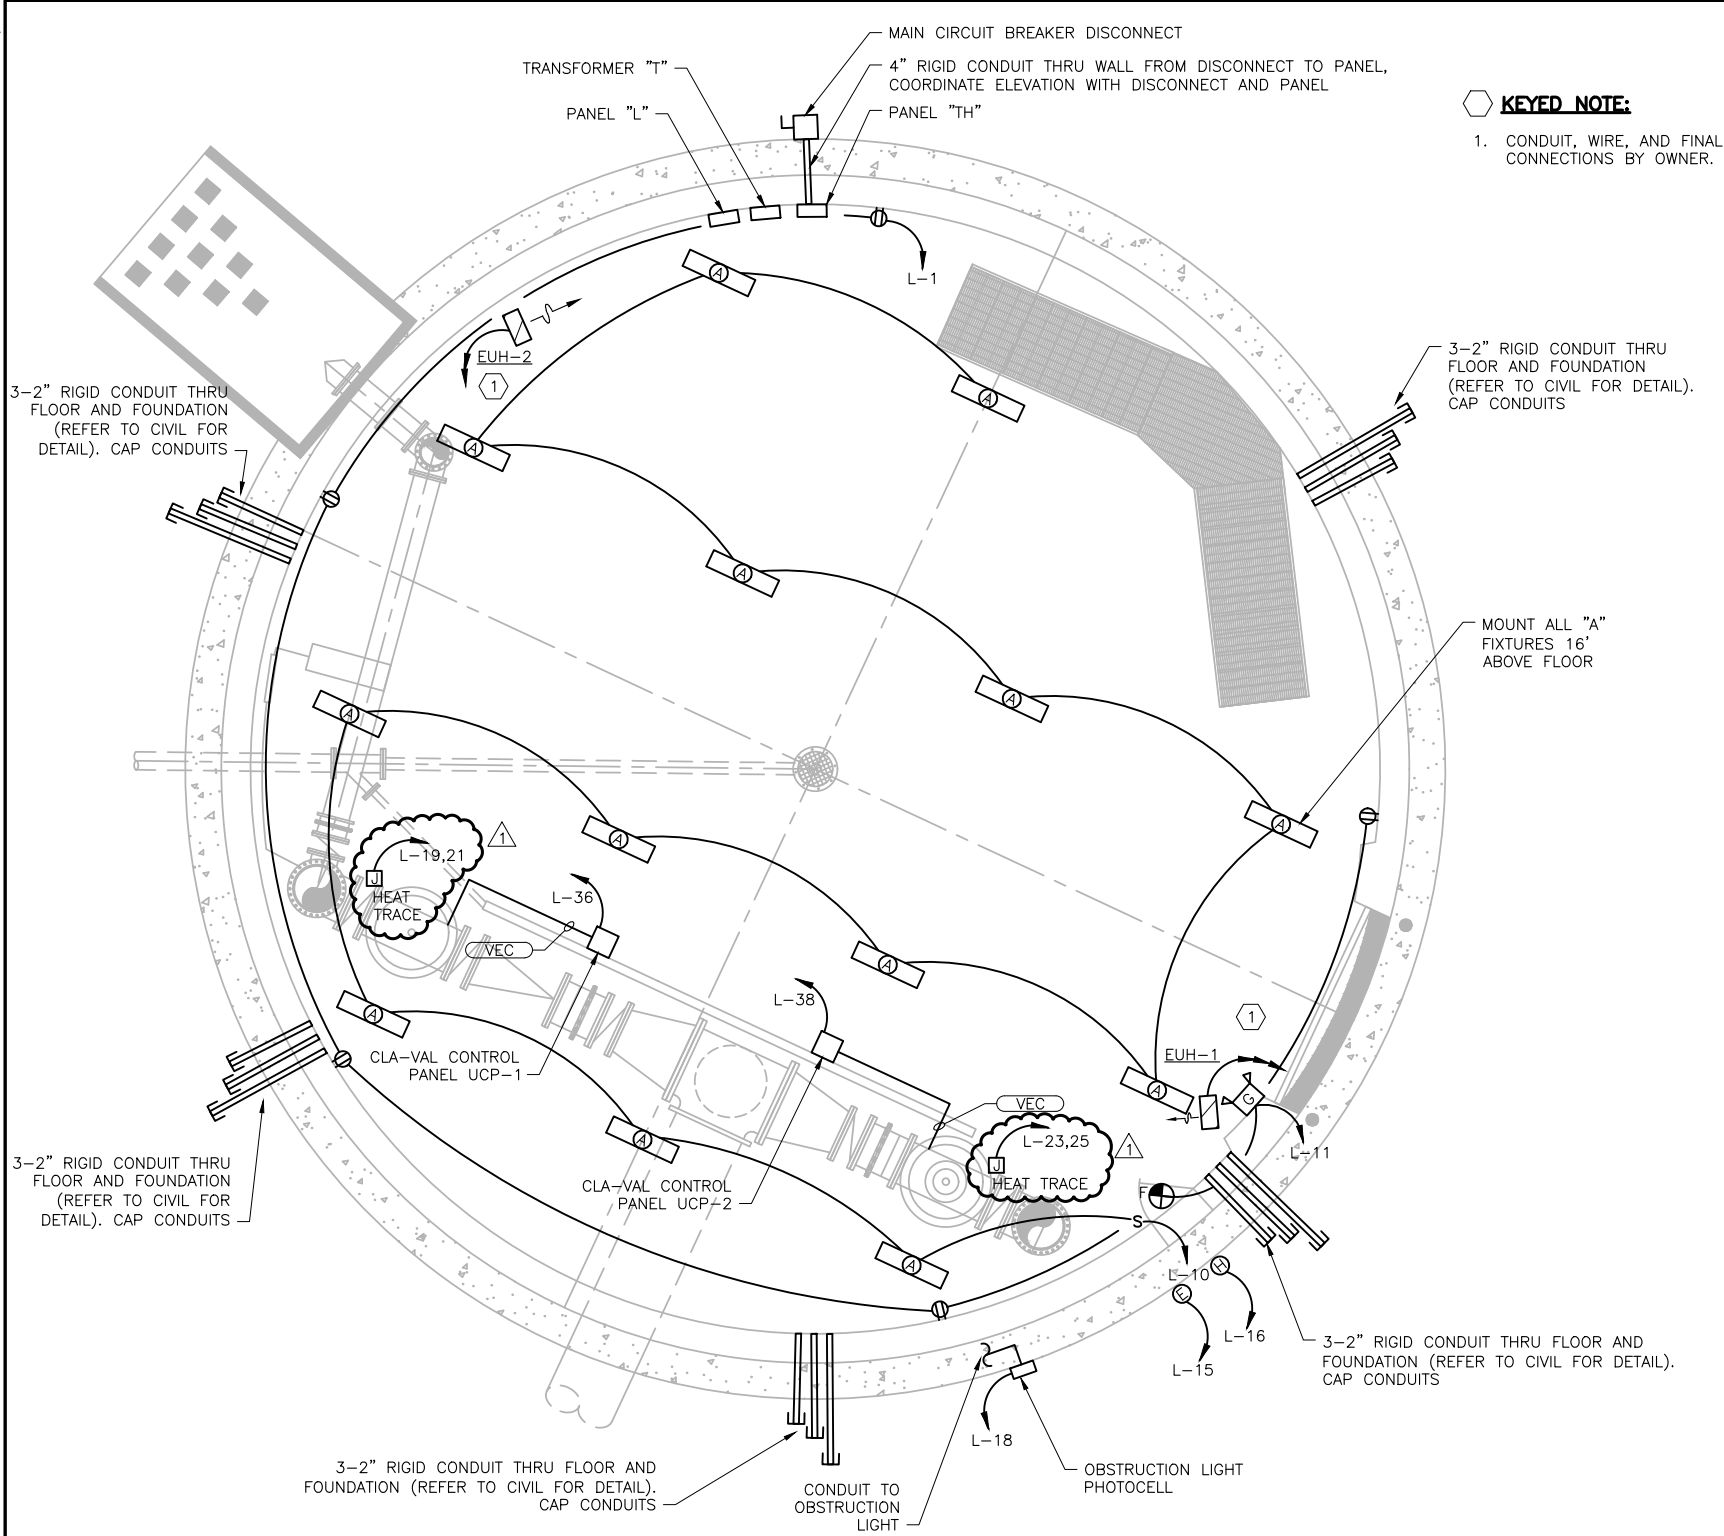


1
E4
GROUND FLOOR LIGHTING PLAN
SCALE: 3/16" = 1'-0"

KEYED NOTE:

1. CONDUIT, WIRE, AND FINAL CONNECTIONS BY OWNER.

LEGEND:

VEC VENDER DEFINED CABLE

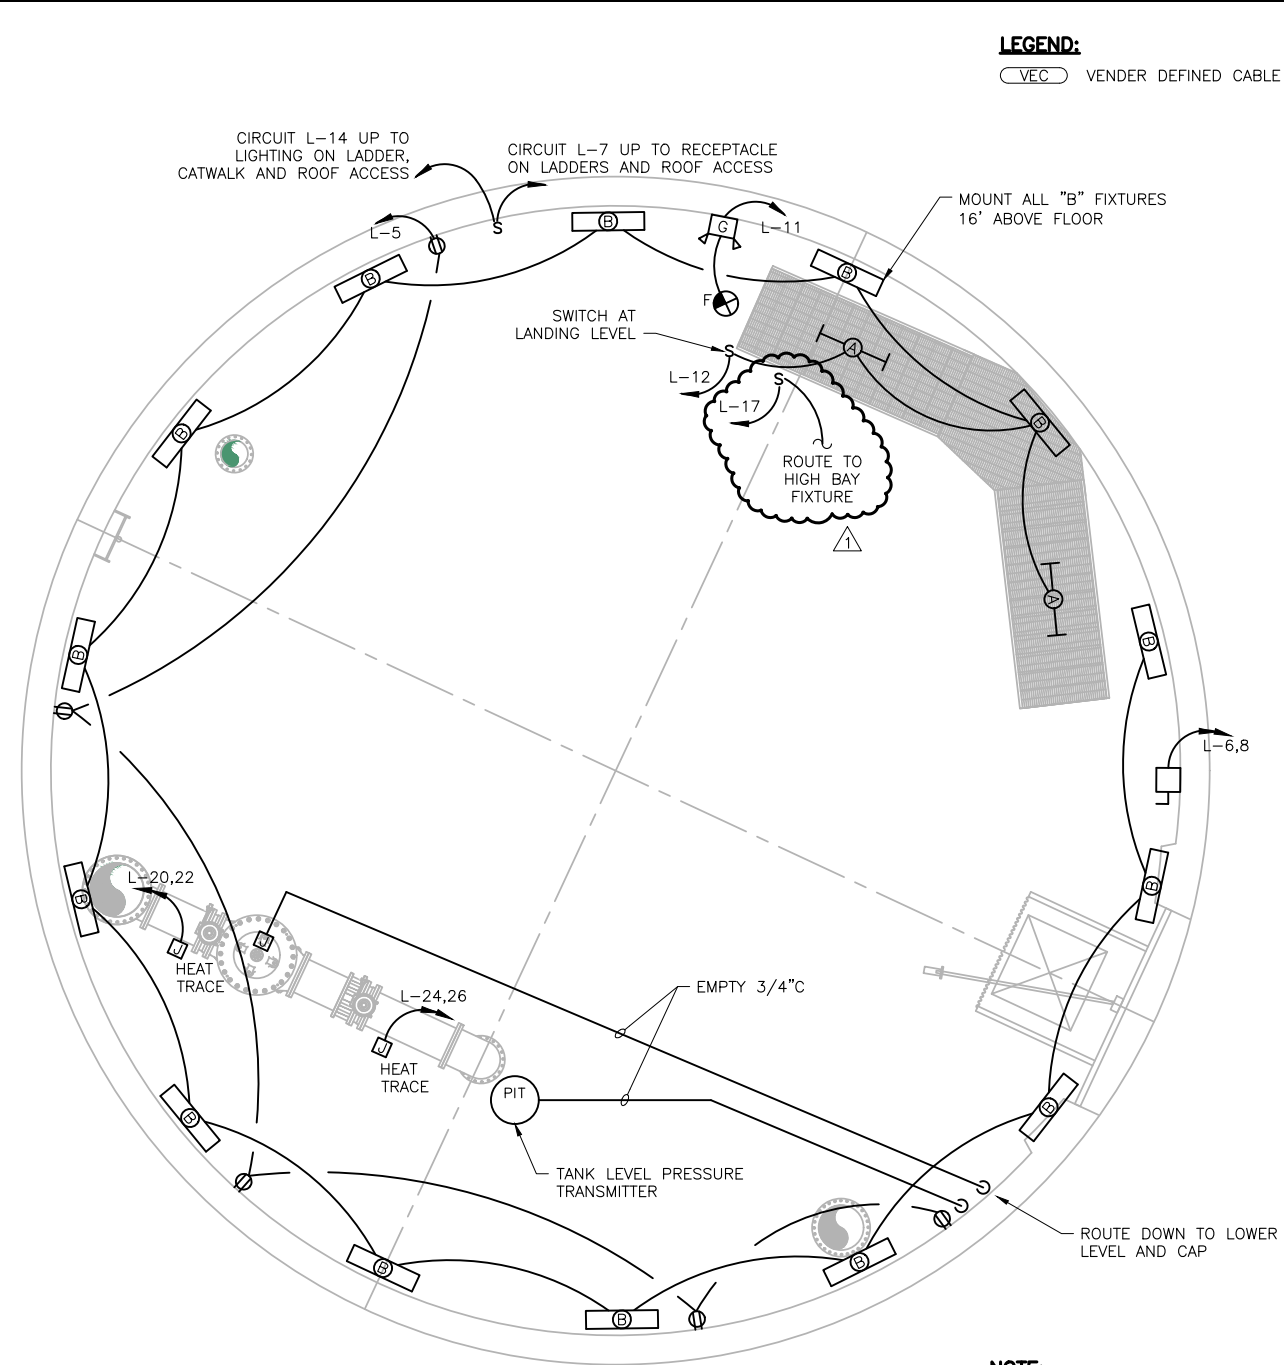

2
E4
INTERMEDIATE FLOOR ELECTRICAL PLAN
SCALE: 3/16" = 1'-0"

NOTE:

CONTRACTOR TO COORDINATE FINAL VOLT AND AMPERAGE RATING OF JIB CRANE AND UPDATE AND VERIFY PANEL SCHEDULE AS APPROPRIATE.

REV. NO.	DATE	DRWN	CHKD	REMARKS
1	9-21-22	CD	BB	ADDENDUM 3



0 1" = 1"
THIS LINE MEASURES 1" WHEN PLOTTED FULL SIZE

DESIGNED:	BB
DRAFTED:	CD
CHECKED:	BB
DATE:	AUGUST 2022



CRIST ENGINEERS, INC.
CONSULTING ENGINEERS

205 EXECUTIVE COURT
LITTLE ROCK, ARKANSAS 72205
TELEPHONE: (501) 664-1552
FAX: (501) 664-8579
WWW.CRISTENGINEERS.COM

ROGERS, ARKANSAS
CAPITAL IMPROVEMENTS PLAN PHASE 1A
WATER TREATMENT PLANT IMPROVEMENTS


ELECTRICAL
TANK PLANS



JOB NO.
CRI-024
SHEET NO.
E4


P:\PRODUCTION\PROJECTS\CRIST ENGINEERS (CRI)\CRI-024 BWPWA ELEVATED TANK\DWG\E04A_TANK PLAN.DWG
9/23/2022 12:40 PM
P:\PRODUCTION\PROJECTS\CRIST ENGINEERS (CRI)\CRI-024 BWPWA ELEVATED TANK\DWG\E04A_TANK PLAN.DWG
9/23/2022 12:40 PM
P:\PRODUCTION\PROJECTS\CRIST ENGINEERS (CRI)\CRI-024 BWPWA ELEVATED TANK\DWG\E04A_TANK PLAN.DWG
9/23/2022 12:40 PM

CRISTENGINEERS, INC.
COPYRIGHT ©

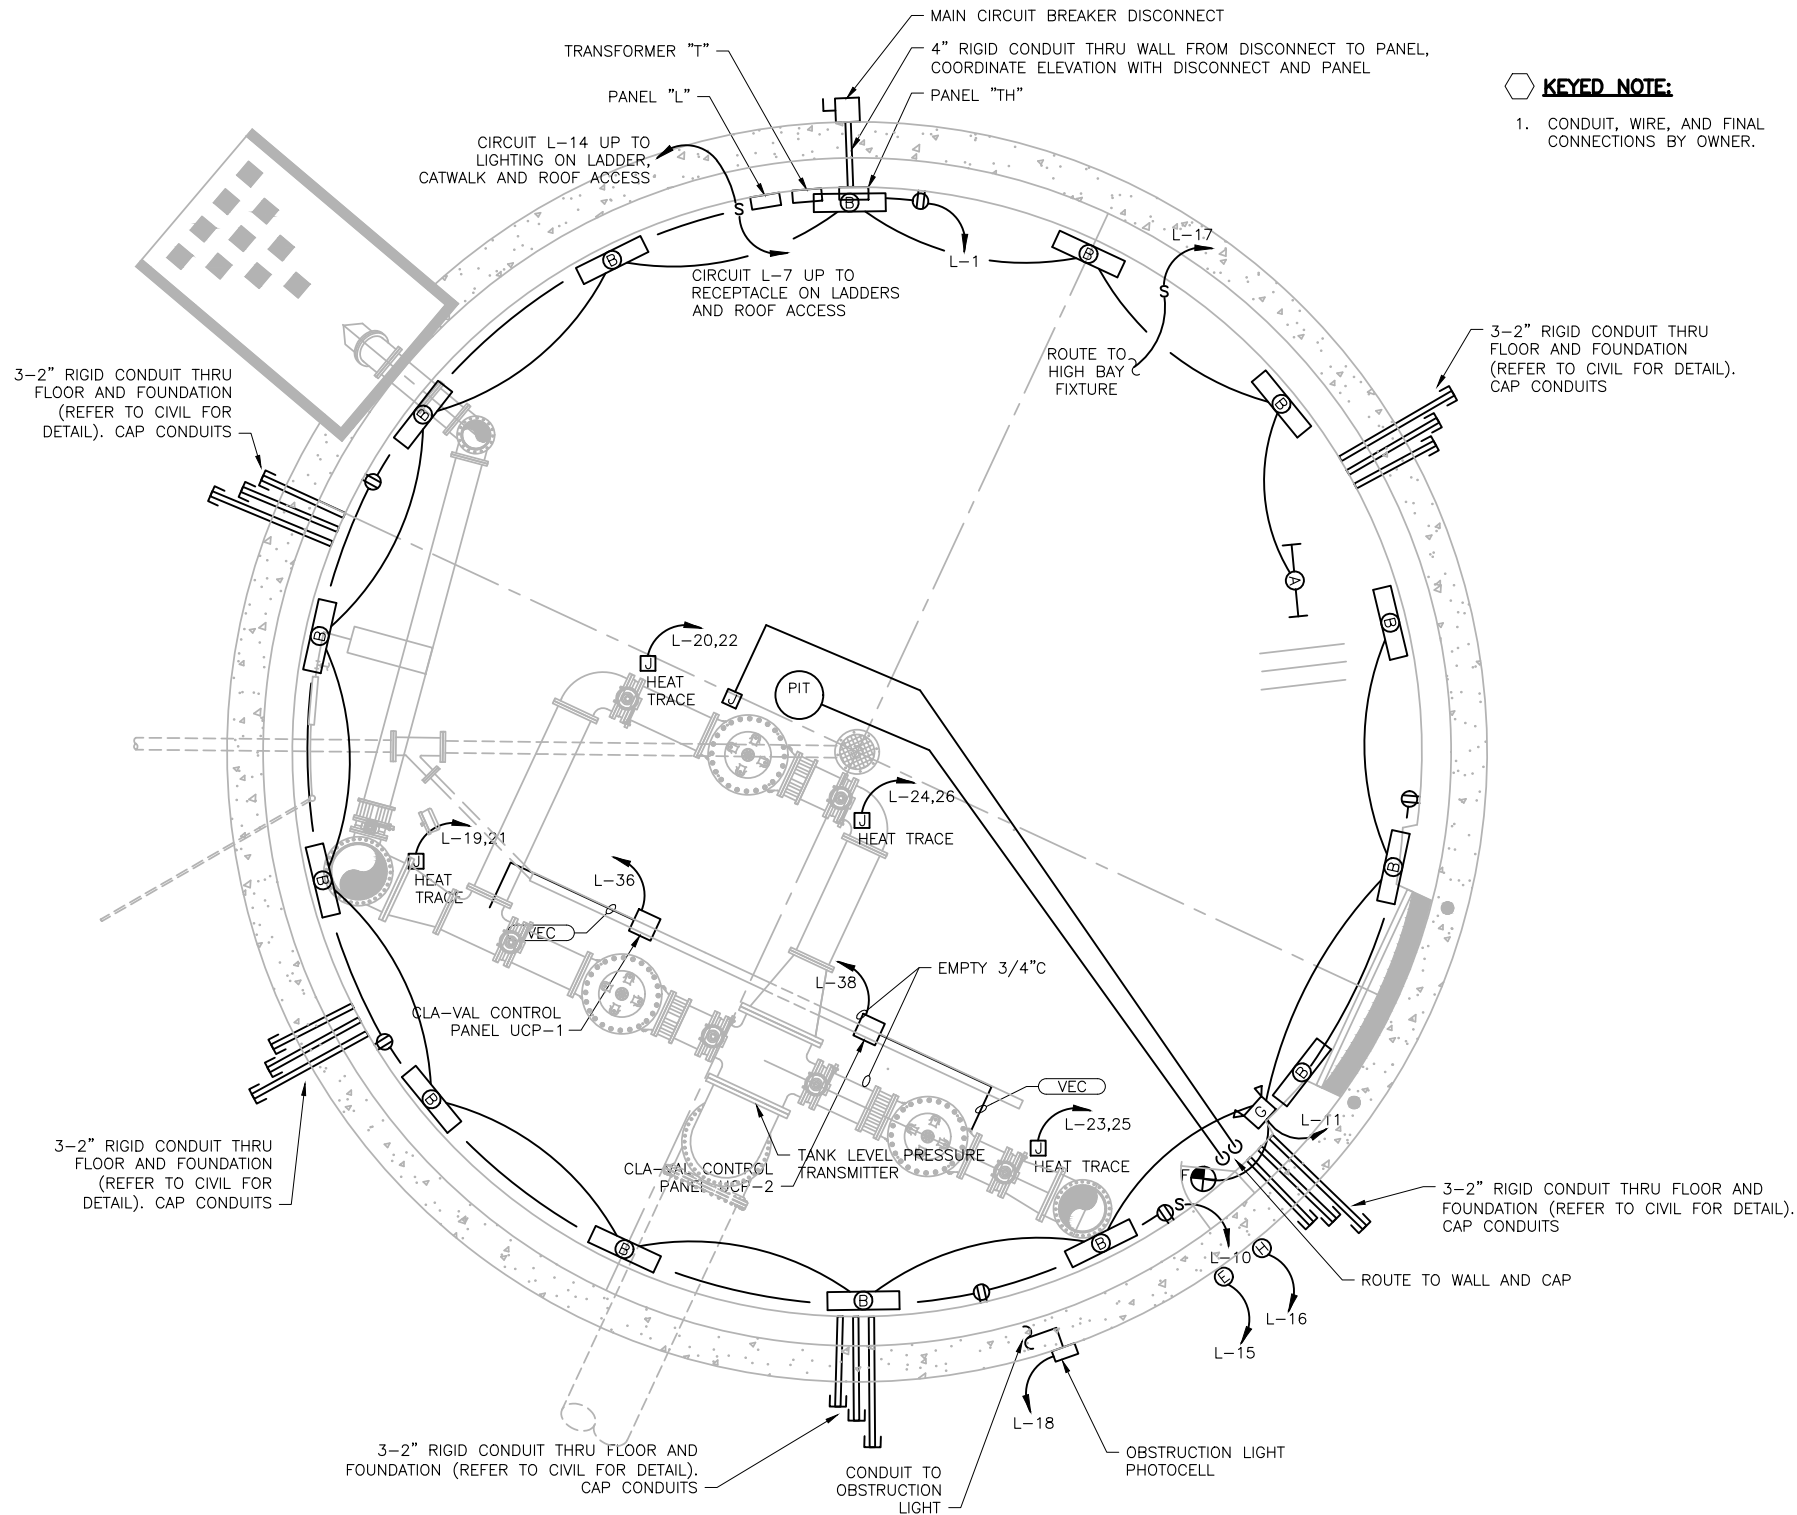

1
E4A
GROUND FLOOR LIGHTING PLAN
SCALE: 3/16" = 1'-0"

REV. NO.	DATE	DRWN	CHKD	REMARKS
1	9-21-22	CD	BB	ADDENDUM 3

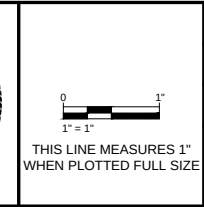

DESIGNED:	BB
DRAFTED:	CD
CHECKED:	BB
DATE:	AUGUST 2022



CRIST ENGINEERS, INC.
CONSULTING ENGINEERS
205 EXECUTIVE COURT
LITTLE ROCK, ARKANSAS 72205
TELEPHONE: (501) 664-1552
FAX: (501) 664-8579
WWW.CRISTENGINEERS.COM

ROGERS, ARKANSAS

**CAPITAL IMPROVEMENTS PLAN PHASE 1A
WATER TREATMENT PLANT IMPROVEMENTS**


ELECTRICAL
TANK PLANS



BROWN ENGINEERS
501-448-0100

JOB NO.	CRI-024
SHEET NO.	E4A

P:\PRODUCTION\PROJECTS\CRIST ENGINEERS (CRI)\CRI-024 BWPWA ELEVATED TANK\DWG\M01_TANK HVAC PLAN.DWG
8/19/2022 4:36 PM
COPYRIGHT © CRIST ENGINEERS, INC.

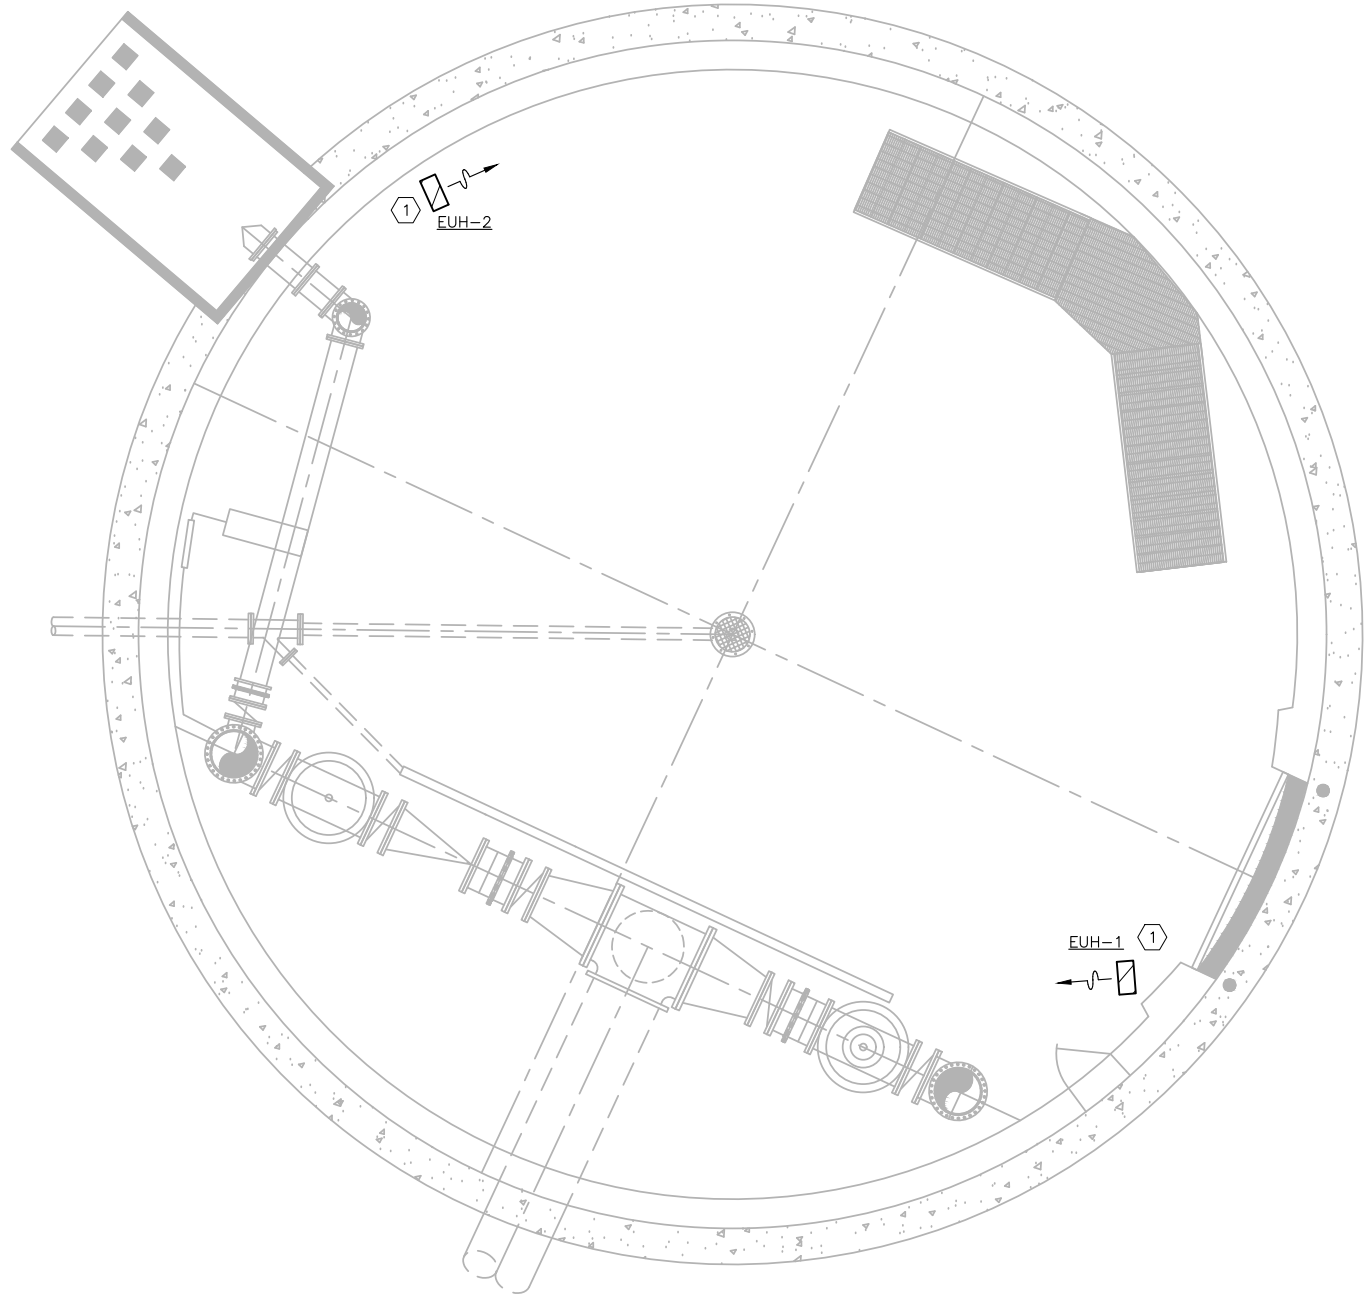

1
M1
GROUND FLOOR HVAC PLAN
SCALE: 3/16" = 1'-0"

KEYED NOTES:

1. ELECTRIC UNIT HEATERS EUH-1 AND EUH-2 EQUAL TO MARKEL P3PUH20CA2-DT. EACH HEATER SHALL PROVIDE 20kW HEAT OPERATING ON 480V/3PH. PROVIDE WITH MANUFACTURER'S DISCONNECT SWITCH, BUILT-IN THERMOSTAT, AND CEILING OR WALL MOUNTING BRACKET. MOUNT HEATERS AT APPROXIMATELY 10' ABOVE FFE.

THERMOSTAT NOTES:

1. PROVIDE ALL EXHAUST FAN THERMOSTATS WITH MANUAL OVERRIDE SWITCH.
2. HEATER THERMOSTATS SHALL ENERGIZE HEATERS AT 50°F AND DE-ENERGIZE AT 55°F (ADJUSTABLE).
3. MOUNT ALL THERMOSTATS APPROX. 48" A.F.F. PER ADA REQUIREMENTS. THERMOSTATS SHALL BE ACCESSIBLE FROM CENTRAL CATWALK. COORDINATE FINAL MOUNTING LOCATION OF THERMOSTATS WITH OWNER.

ALL WORK THIS SHEET WILL BE BY OWNER



REV. NO.	DATE	DRWN	CHKD	REMARKS



0 1" = 1"
THIS LINE MEASURES 1" WHEN PLOTTED FULL SIZE

DESIGNED:	AL
DRAFTED:	CD
CHECKED:	MCR
DATE:	AUGUST 2022



CRIST ENGINEERS, INC.
CONSULTING ENGINEERS

205 EXECUTIVE COURT
LITTLE ROCK, ARKANSAS 72205
TELEPHONE: (501) 664-1552
FAX: (501) 664-8579
WWW.CRISTENGINEERS.COM

ROGERS, ARKANSAS
CAPITAL IMPROVEMENTS PLAN PHASE 1A
WATER TREATMENT PLANT IMPROVEMENTS

HVAC
TANK PLANS

JOB NO.	CRI-024
SHEET NO.	M1