



ADDENDUM NO. 02

To: Prospective Bidders & Plan Holders

From: Craig A. Johnson, P.E.
Crist Engineers, Inc.

Date: January 16, 2023

Project: Wastewater Treatment Facility
Headworks Improvements
Paragould Light, Water, & Cable
Paragould, Arkansas

Bid Date: January 19, 2023

Bid Time: 2:00 PM

Location: Paragould Light, Water, & Cable
1901 Jones Road
Paragould, Arkansas 72450

The BIDDER shall properly acknowledge Addendum No. 02 as required in Article 3 of Document 004100 on the Bid Form as confirmation that the BIDDER has examined the following Addenda and the related changes to the Contract Documents. Lack of proper acknowledgement on the Bid Form may deem a bid non-responsive.

The Contract Documents dated December 27, 2023, are hereby amended as follows:





Prospective Bidders & Plan Holders
Addendum No. 02
Wastewater Treatment Facility Headworks Improvements
Page 2 of 2

IMPORTANT REMINDERS:

The bid opening for this project is 2:00 PM on January 19, 2023.

Please reference Section 002113 - Instructions to Bidders, provided in the contract documents for information required for the bid submission.

BID DOCUMENTS:

1. 004000 – Bid Form
 - a. Delete Bid Form Page 9 – Addendum No. 1 in its entirety and replace with Bid Form Page 9 – Addendum No. 2, attached hereto.

DRAWINGS:

1. Drawing C-4 – Yard Piping Plan:
 - a. Modify this drawing as shown on the Addendum No. 2 – Yard Piping Plan, attached hereto.
1. Drawing S-2 – Foundation Plan:
 - a. Modify this drawing as shown on the Addendum No. 2 – Foundation Plan, attached hereto.

END ADDENDUM NO. 02

DEDUCTIVE ALTERNATES CITY OF PARAGOULD, ARKANSAS PARAGOULD LIGHT, WATER, & CABLE WASTEWATER TREATMENT FACILITY HEADWORKS IMPROVEMENTS		
Deductive Alternative	Description for Deduction	Bid Price
A.	Under Deductive Alternate A, all work, equipment, materials, and other costs for <u>Demolition of the Existing Grit Chamber & Washer Area and Existing Screen Structure Area per Addendum No. 01</u> , Reference ADD. No. 1/D-1 and ADD. No. 1/D-1 will be deleted from the Work and will be deducted from the Total Lump Sum Base Bid Amount.	\$ _____
B.	Under Deductive Alternative B, all work, equipment, and materials to substitute PRAH Antimicrobial Crystalline Admixture with PRAH Regular Crystalline Admixture as required in the Cast in Place Concrete Specification Section 033000.	\$ _____ (Lump Sum)

5.02 Schedule of Major Equipment: NOT APPLICABLE.

ARTICLE 6 – TIME OF COMPLETION

- 6.01 Bidder agrees that the Work will be substantially complete and will be completed and ready for final payment in accordance with Paragraph 15.06 of the General Conditions on or before the dates or within the number of calendar days indicated in the Agreement.
- 6.02 Bidder accepts the provisions of the Agreement as to liquidated damages.


ARTICLE 7 – ATTACHMENTS TO THIS BID

- 7.01 The following documents are submitted with and made a condition of this Bid:
- A. Required Bid security;
 - B. List of Proposed Subcontractors;
 - C. Copy of current Arkansas Contractor's License

ARTICLE 8 – DEFINED TERMS


- 8.01 The terms used in this Bid with initial capital letters have the meanings stated in the Instructions to Bidders, the General Conditions, and the Supplementary Conditions.

P:\2020 Projects\2023 - PLWC WWTP Improvements - Headworks\06 - CADD\02 - Civil\02 - Yard Piping PP.dwg

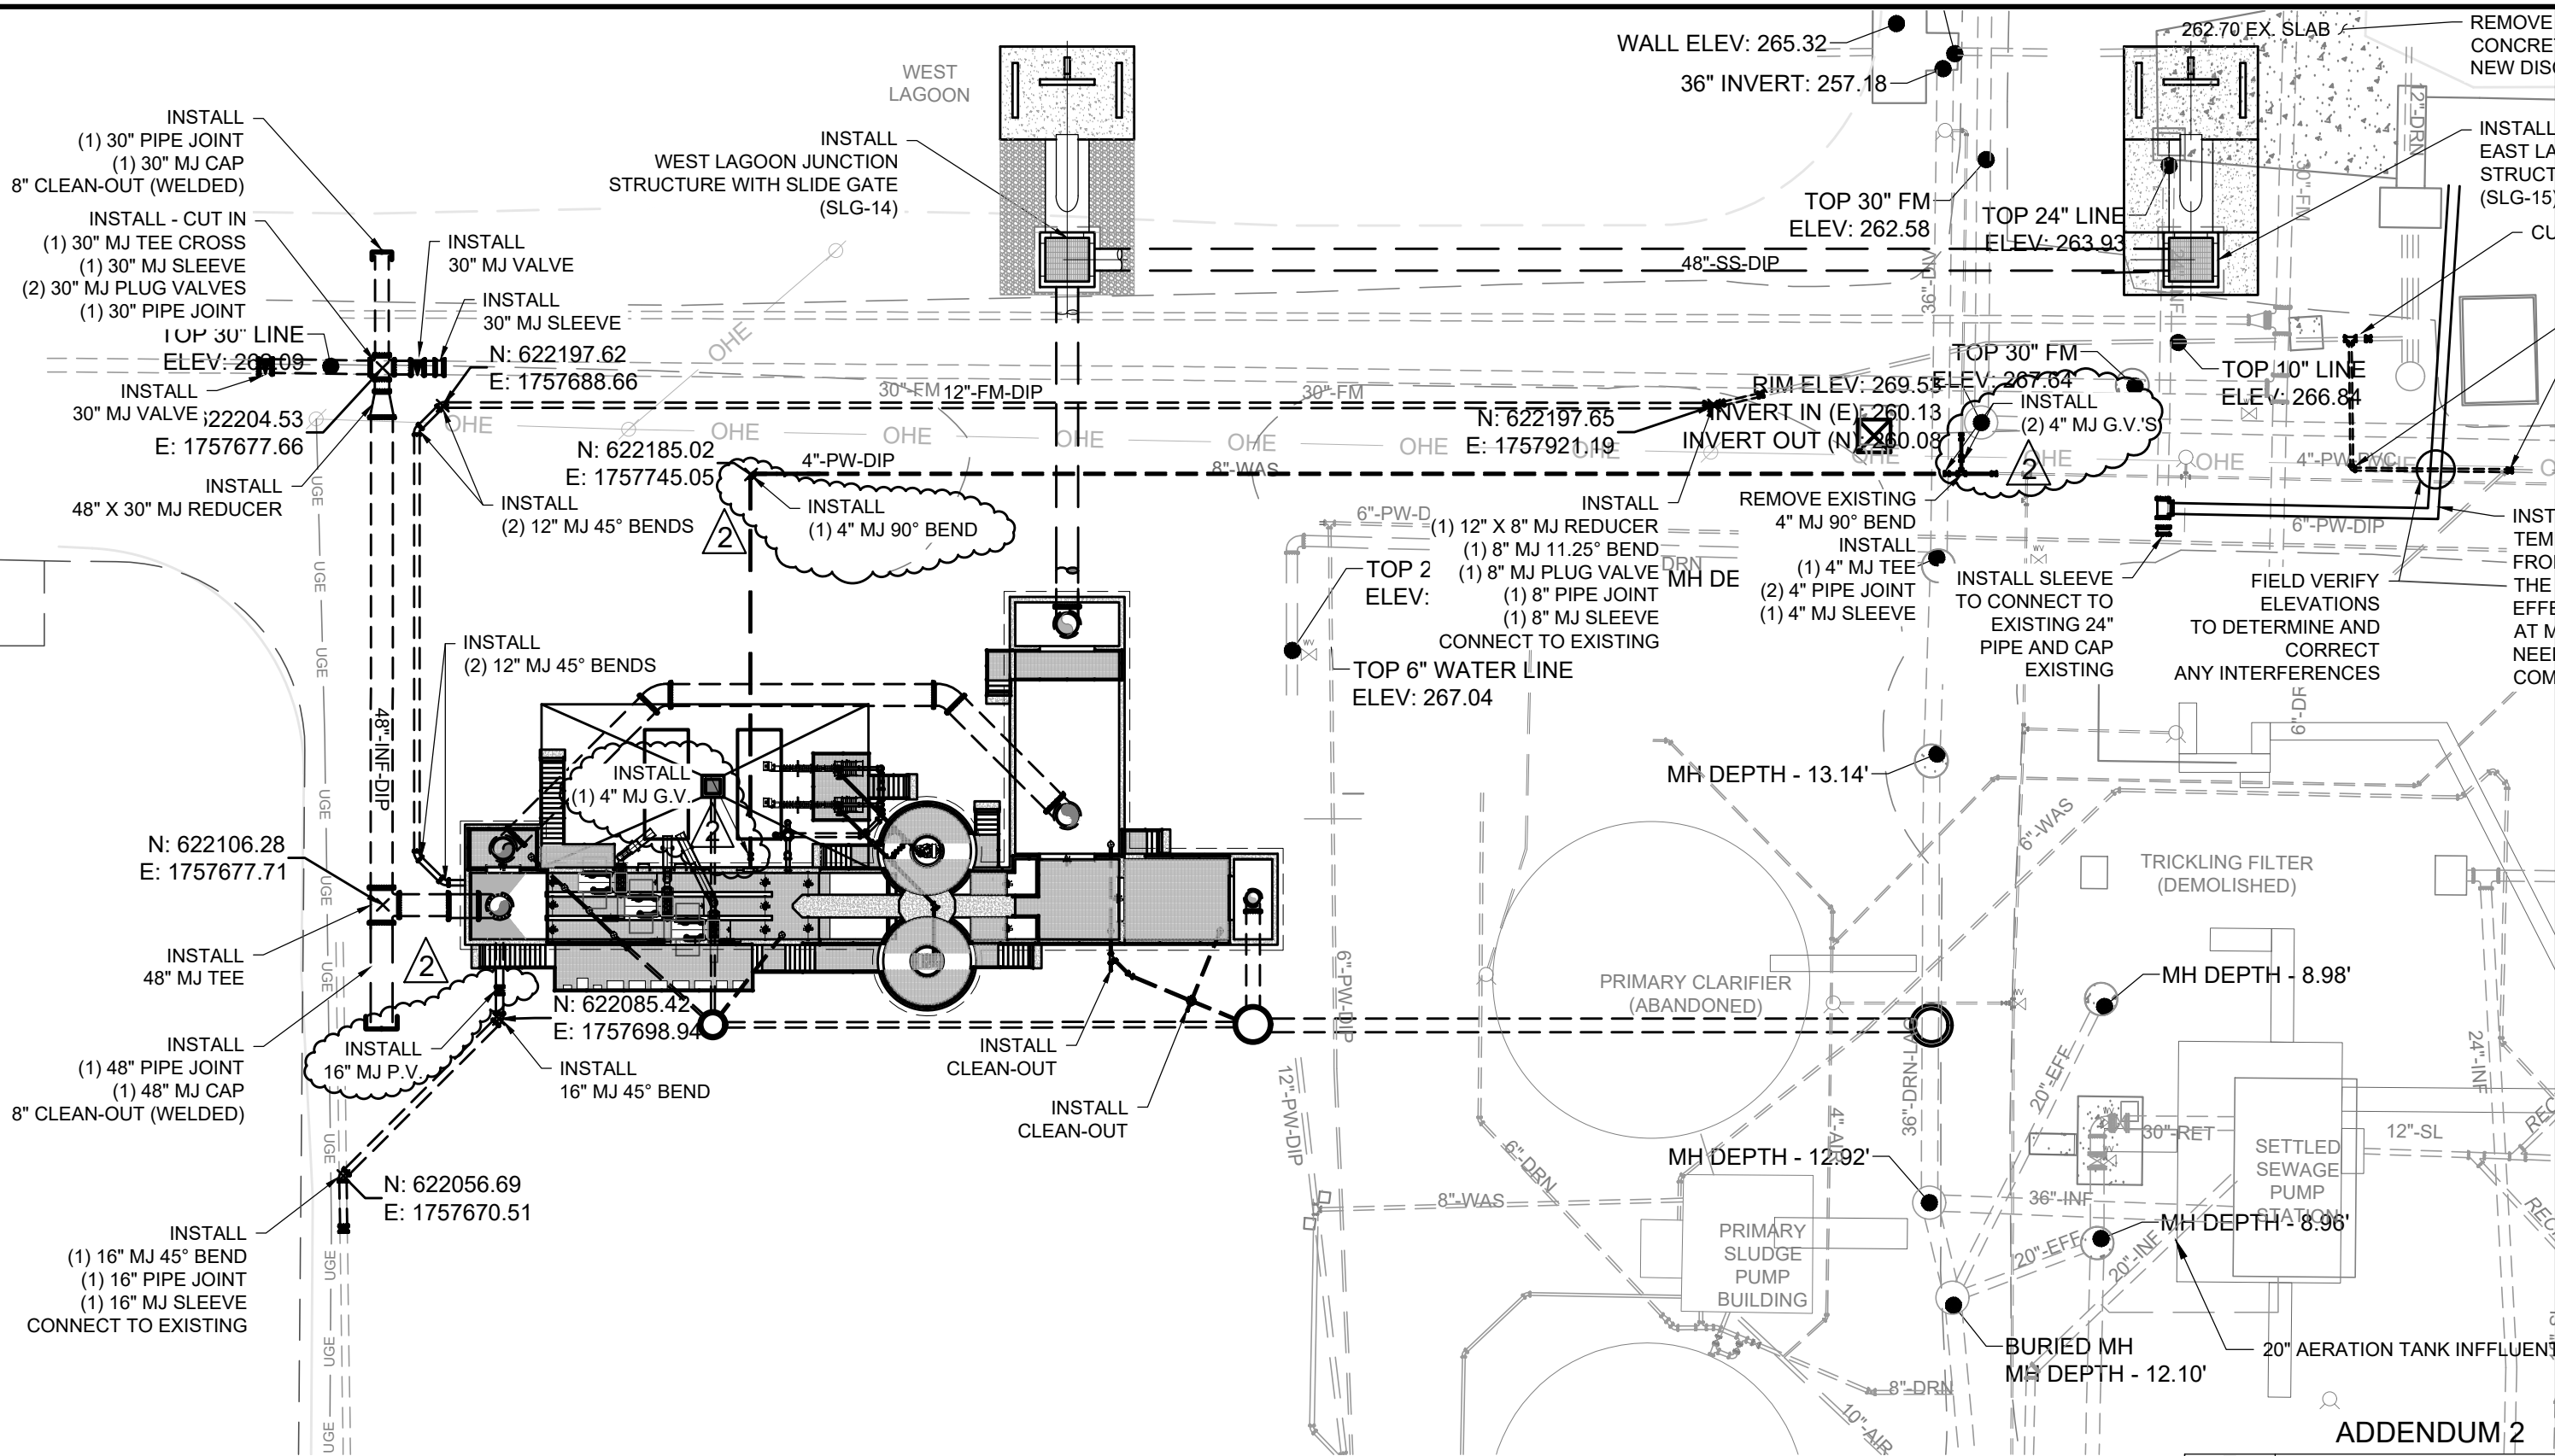

YARD PIPING PLAN C-4


SCALE: 1:30

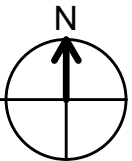


ADDENDUM 2

CRIST ENGINEERS, INC.			
CONSULTING ENGINEERS LITTLE ROCK, ARKANSAS			
PARAGOULD, ARKANSAS			
PARAGOULD, LIGHT WATER & CABLE			
HEADWORKS IMPROVEMENTS			
YARD PIPING PLAN			
DESIGNED: CAJ	JOB NO. 2023	DATE JAN. 2023	ADD. NO. 2
DRAFTED: SBM	SCALE:	NOT TO SCALE	REF SHEET C-4
CHECKED: CAJ			


D:\ACAD\CRIST\Project Folders\2023 - Paragould Light, Water & Cable\2023 - Headworks.dwg

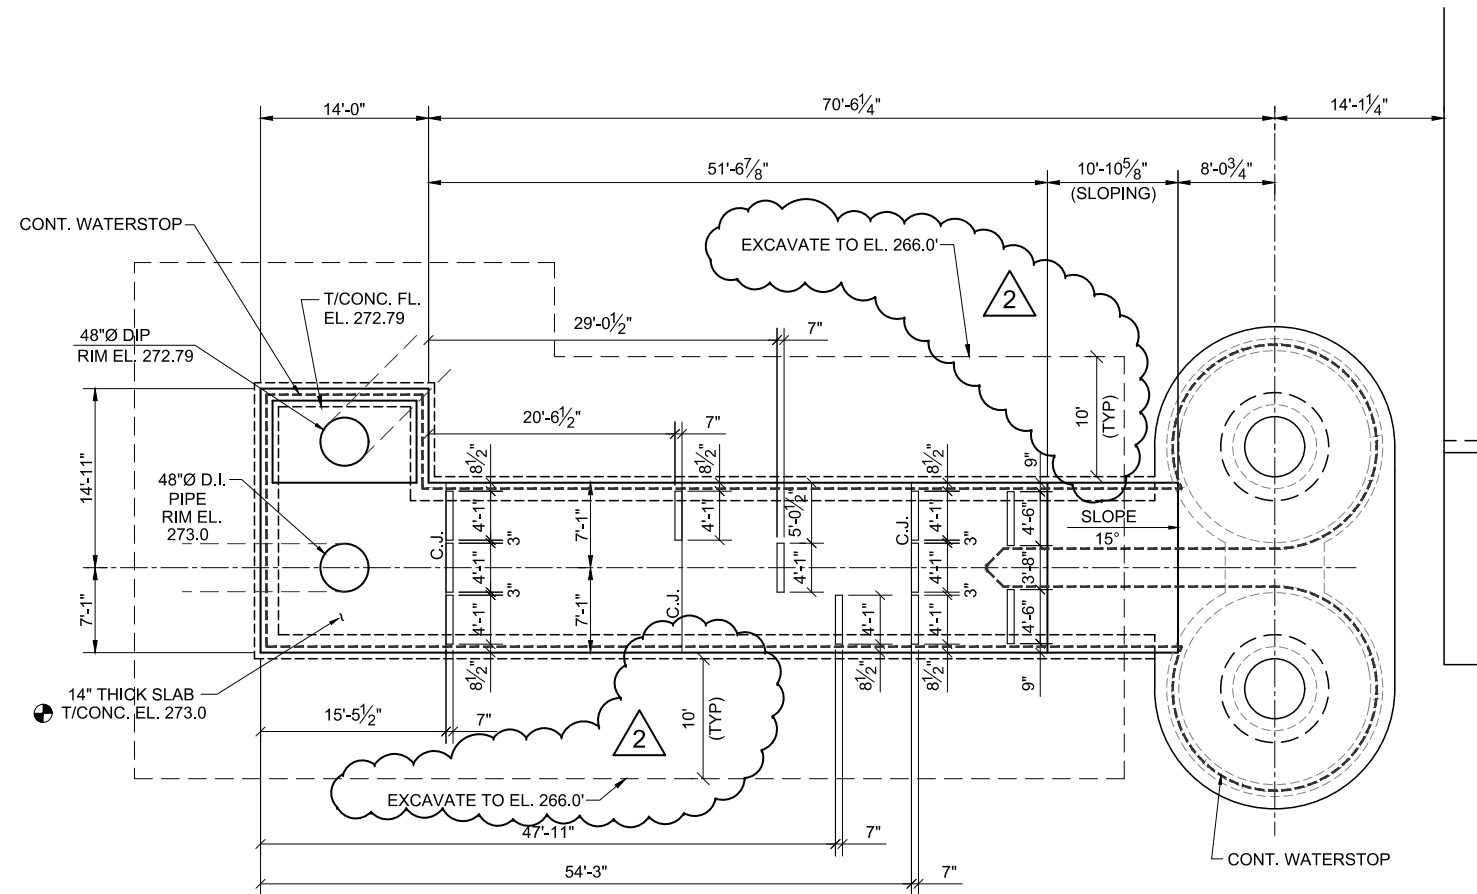


SEQUENCE 3 - FOUNDATION
PLAN
1/8" = 1'-0"

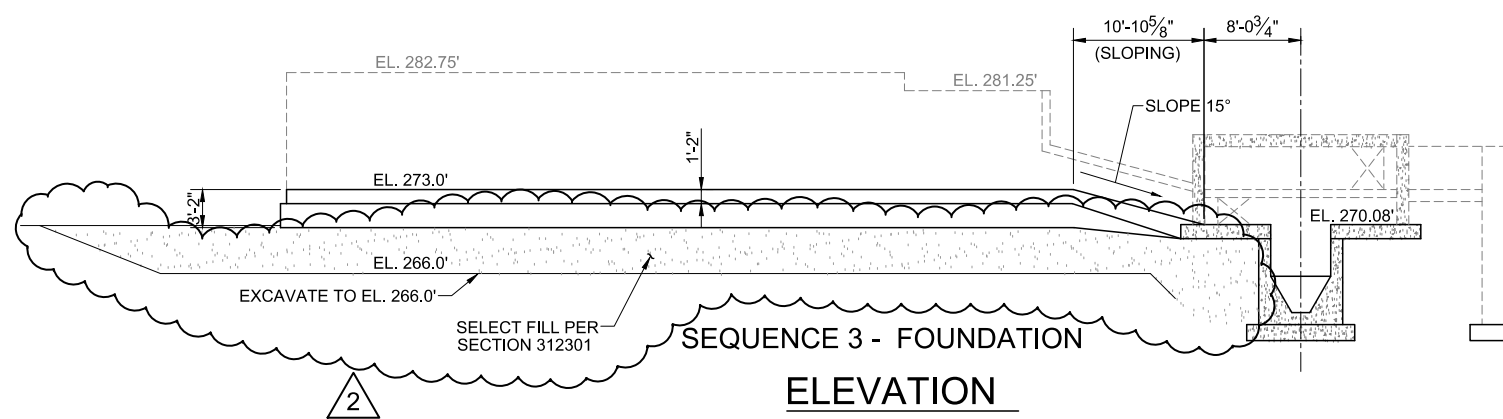

SEQUENCE 3 - FOUNDATION
ELEVATION
1/8" = 1'-0"

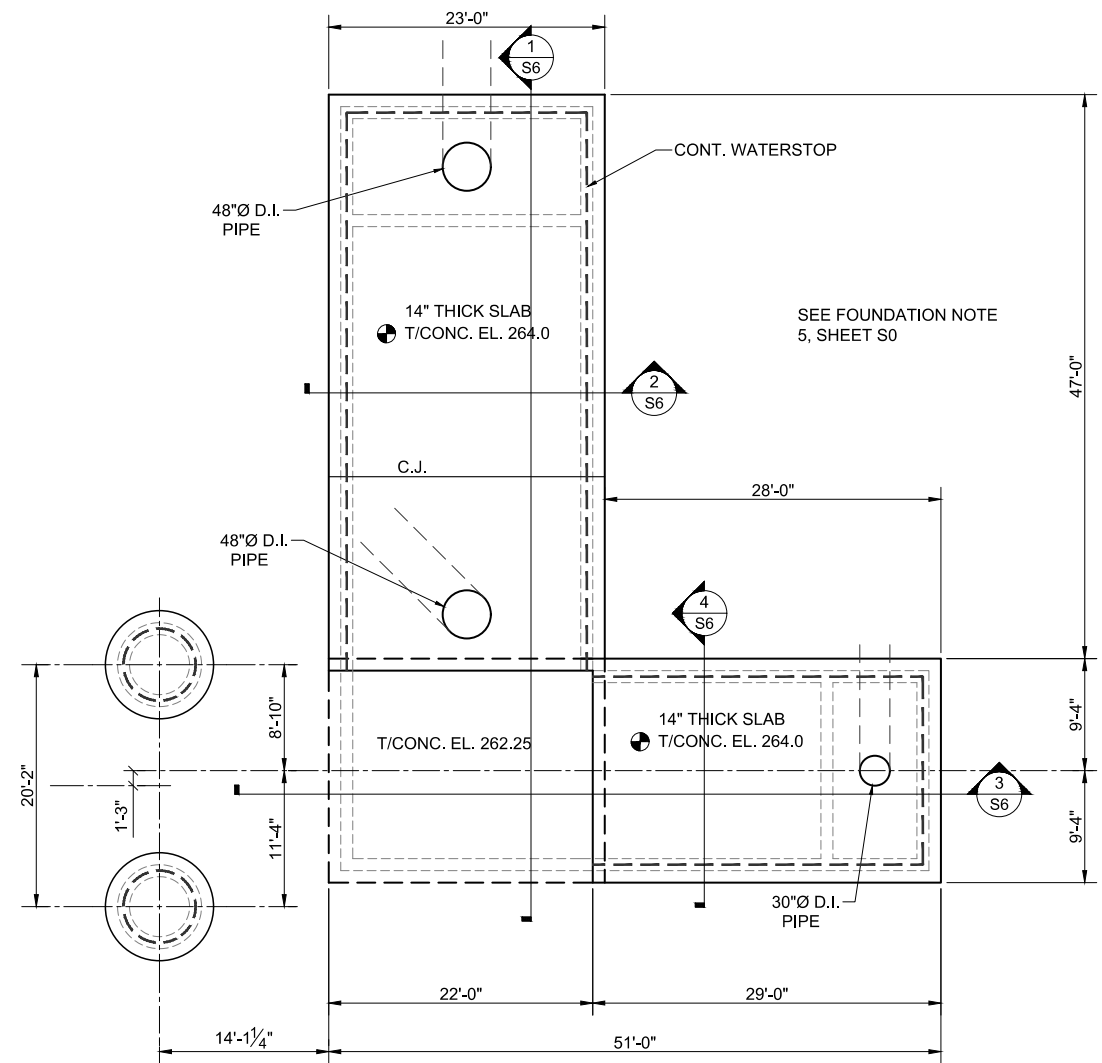

SEQUENCE 1A - FOUNDATION
PLAN
1/8" = 1'-0"

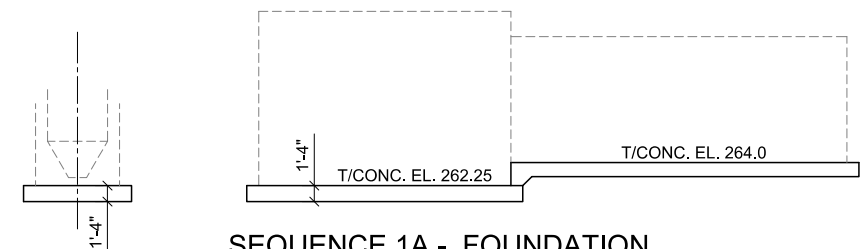

SEQUENCE 1A - FOUNDATION
ELEVATION
1/8" = 1'-0"

ADDENDUM 2

		CRIST ENGINEERS, INC.	
		CONSULTING ENGINEERS LITTLE ROCK, ARKANSAS	
PARAGOULD, ARKANSAS			
PARAGOULD LIGHT, WATER & CABLE HEADWORKS IMPROVEMENTS			
HGL - FOUNDATION PLANS			
DESIGNED: MER	JOB NO. 2023	DATE JAN 2023	ADD. NO. 2
DRAFTED: GAC	SCALE:	AS SHOWN	REF SHEET S2
CHECKED: MER			