

Crist Engineers, Inc.

1 Executive Center Court
Little Rock, Arkansas 72211
(501) 664-1552
www.cristengineers.com

**Consulting Engineers**

Matthew D. Dunn
Craig A. Johnson
Brian N. Wintle

ADDENDUM NO. 1

DATE: July 14, 2026

PROJECT: Tull Master Meter Vault
Malvern Water Works
Malvern, Arkansas

BID DATE: July 21, 2026, 2:00 PM

This Addendum forms a part of the Contract Documents and modifies the original documents provided to Bidders, as noted below. Acknowledge receipt of this Addendum in the space provided in the BID FORM. Failure to do so may subject the Bidder to disqualification.

The Contract Documents for the above Project are hereby amended as follows:

Item No. 1 DRAWINGS

- A. Sheet 3 – Site Plan
 - i. Modify this drawing as shown on the Addendum No. 1 – Site Plan, attached hereto:

END OF ITEMS


All other provisions of the Contract Documents remain unchanged. Acknowledge receipt of this addendum on the Bid Form. Bids must be received by Malvern Water Works at 506 Overman Street, Malvern, Arkansas 72104 by 2:00 PM, July 21, 2026.

CRIST ENGINEERS, INC.

A blue ink signature of Mason Allen, written in a cursive style.

Mason Allen, P.E.

P:\2025 Projects\25034 - Malvern Water Works - Tull Master Meter Vault - CADD\01 - Civil\2_3 - 25034 - Site & Meter Plan.dwg

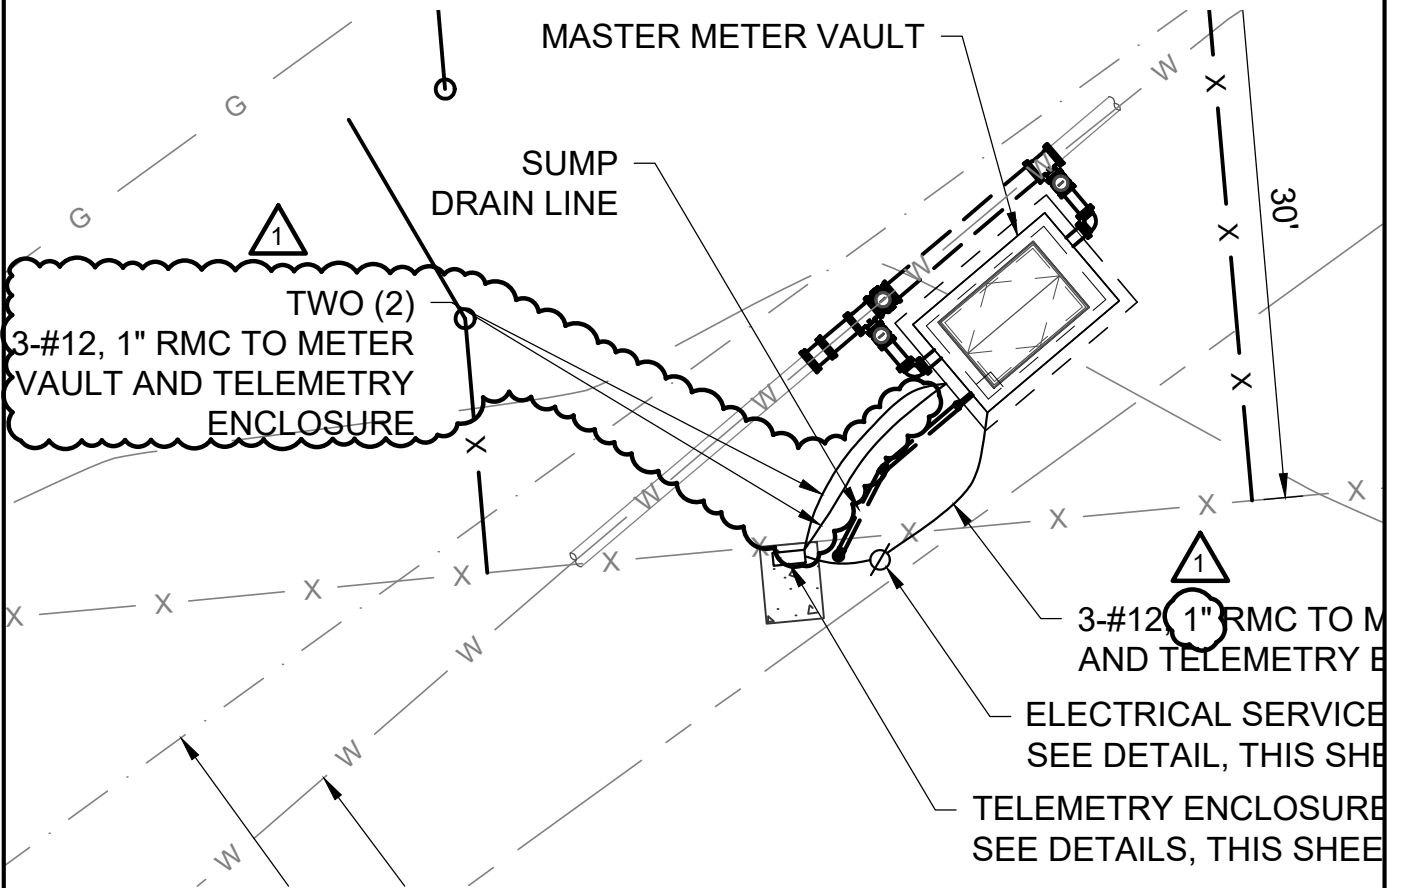

		CRIST ENGINEERS, INC.	
CONSULTING ENGINEERS		LITTLE ROCK, ARKANSAS	
MALVERN, ARKANSAS			
MALVERN WATER WORKS			
TULL MASTER METER VAULT			
SITE PLAN			
DESIGNED: MPA	JOB NO. 25034	DATE JULY 2026	ADD. NO. 1
DRAFTED: MPA	SCALE: AS SHOWN	REF SHEET 3	
CHECKED: MPA			